


REVISIONS
1-1-40
2-7-41
1-1-42
1-1-43
1-1-44
1-1-45

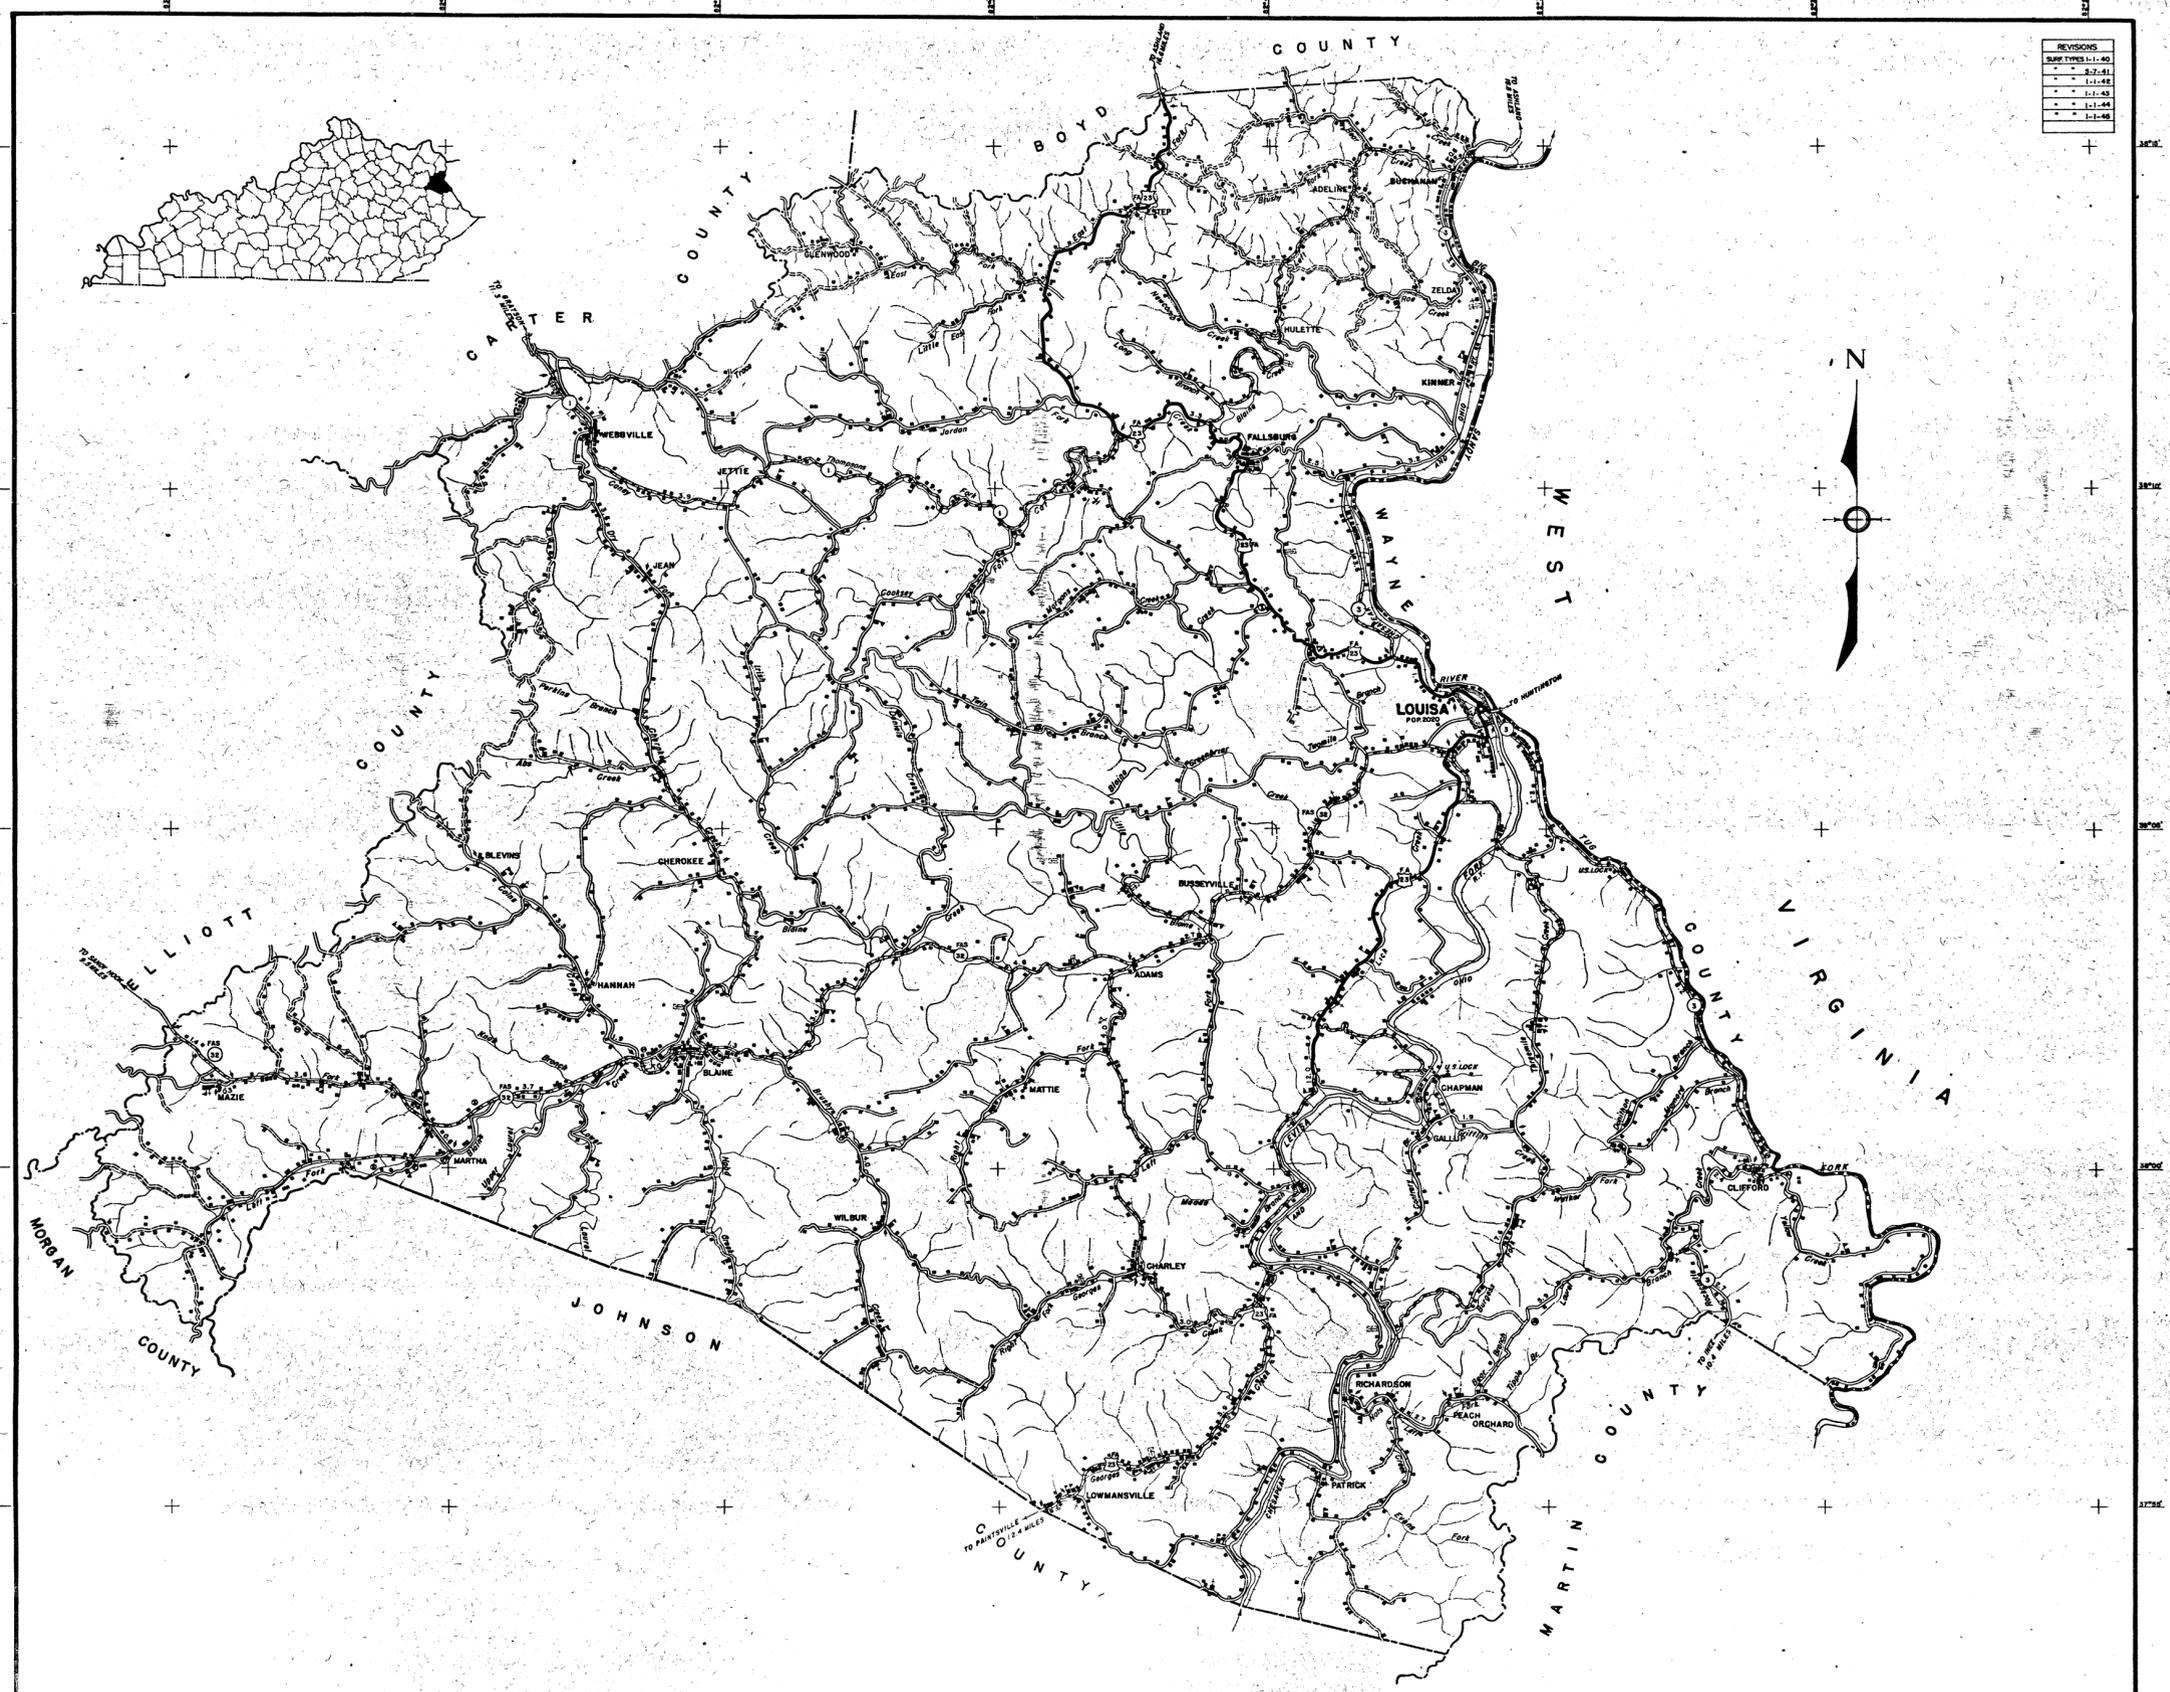

L E G E N D

<ul style="list-style-type: none"> □ MONUMENT SMALL □ GOLF COURSE OR COUNTRY CLUB □ FAIR GROUNDS, RACE COURSES, SPEEDWAYS □ CEMETERY □ CHURCH WITH CEMETERY ADJACENT IN USE NOT IN USE □ FARM UNIT □ DWELLINGS OTHER THAN FARMS □ HOUSE OR GROUPS OF DWELLINGS CLOSELY SPACED □ STORE OR SMALL BUSINESS ESTABLISHMENT □ COMBINED DWELLING AND STORE □ HOTEL □ CHURCH, OTHER RELIGIOUS INSTITUTIONS □ SCHOOL, HOUSE, OTHER EDUCATIONAL INSTITUTIONS □ HOSPITALS □ FACTORY OR INDUSTRIAL PLANT □ SEASONAL OR SUMMER COLONY DWELLINGS □ SEASONAL DWELLINGS CLOSELY SPACED □ CCC CAMP □ AIRWAY BEACON LIGHT □ ARMY, NAVY OR MARINE CORPS FIELD □ DEPARTMENT OF COMMERCE INTERMEDIATE FIELD □ COMMERCIAL OR MUNICIPAL FIELD □ MARKED AUXILIARY FIELD □ AIRPORT HOUSING FACILITIES □ AIRPLANE LANDING FIELD MARKED OR EMERGENCY 	<ul style="list-style-type: none"> □ SAWMILL (STATIONARY) □ QUARRY OR GRAVEL PIT □ MINE □ OIL OR GAS WELLS □ TANKS □ POWER PLANT □ TERMINAL, STAGE OR COMMUNITY HALL □ FOREST SERVICE LOOKOUT STATION □ GARDENS OF PUMPING STATION □ MUNICIPAL GARAGE OR RUBBISH DUMPS □ STATE ROAD GARAGE □ SEASONAL INDUSTRY (CANNERY OR SMALL GRAIN MILL) □ FRESH AIR FARMS OR REST HOMES □ COUNTY FARM □ CORRECTIONAL INSTITUTION □ RACED STATION □ CAMP GROUND □ TOURIST CAMP □ MUNICIPAL PARK □ PLAYGROUNDS, BALL FIELDS, ETC. □ BATHING BEACHES □ SCENIC SITES □ GAME FARMS □ GAME PRESERVES □ RAILROAD (ANY NUMBER TRACKS) USED BY SINGLE OPERATING COMPANY □ RAILROAD STATION □ RAILROAD GRADE CROSSING □ RAILROAD ABOVE 	<ul style="list-style-type: none"> — RAILROAD BELOW — RAILROAD TUNNEL <p style="text-align: center;">ROAD TYPES</p> <ul style="list-style-type: none"> — TRAIN — PRIMITIVE ROAD — UNIMPROVED ROAD — GRAVEL AND GRADED ROAD — SURFACE ROAD (WIRE WASTE) — METAL SURFACED ROAD — LOW TYPE BITUMINOUS ROAD — PAVED ROAD — VILLAGE INDICATED
---	---	---

HIGHWAY AND TRANSPORTATION MAP LAWRENCE COUNTY KENTUCKY

PREPARED BY THE
KENTUCKY DEPARTMENT OF HIGHWAYS
IN COOPERATION WITH THE
U. S. DEPARTMENT OF AGRICULTURE
BUREAU OF PUBLIC ROADS
DATA OBTAINED FROM
STATE-WIDE HIGHWAY PLANNING SURVEY

SCALE 1:62,500
1937
POLYCONIC PROJECTION